

**LEGEND**

-  SIGN LOCATION
-  TYPE III BARRICADE WITH SIGN
-  PORTABLE CHANGEABLE MESSAGE BOARD
-  PROPOSED DETOUR ROUTE
-  WORK AREA
-  PLACE TRAFFIC CONTROL SIGNS PER "DETAIL C" IN SDD "BARRICADES AND SIGNS FOR MAINLINE CLOSURES"
-  PLACE TRAFFIC CONTROL SIGNS PER "DETAIL E" IN SDD "BARRICADES AND SIGNS FOR MAINLINE CLOSURES"
-  PLACE TRAFFIC CONTROL SIGNS PER "DETAIL 4" IN SDD "BARRICADES AND SIGNS FOR SIDEROAD CLOSURES"

**GENERAL NOTES - DETOUR**



SEE S.D.D. "BARRICADES AND SIGNS FOR MAINLINE CLOSURES", "BARRICADES AND SIGNS FOR VARIOUS CLOSURES", "DETOUR SIGNING FOR MAINLINE CLOSURES", AND "BARRICADES AND SIGNS FOR SIDEROAD CLOSURES" FOR GENERAL NOTES AND SIGN SPACING REQUIREMENTS.

DRAWINGS SHOW TRAFFIC CONTROL FOR A TYPICAL SITUATION. ADDITIONAL TRAFFIC CONTROL DEVICES MAY BE REQUIRED AND/OR LAYOUT DETAILS MODIFIED DEPENDING ON FIELD CONDITIONS AND THE CONTRACTOR'S METHODS OR SEQUENCE OF OPERATION.

ALL EXISTING OR TEMPORARY SIGN MESSAGES THAT CONFLICT WITH THE DETOUR SHALL BE COVERED OR REMOVED.

MAP SHOWN IS NOT TO SCALE.

PCMS MESSAGES		
	7 DAYS PRIOR TO DETOUR	
LOCATION	PHASE 1 (2 SEC.)	PHASE 2 (2 SEC.)
STH 60 EB	ROAD CLOSED BEGINS	{DAY} {DATE XX}
STH 60 WB	ROAD CLOSED BEGINS	{DAY} {DATE XX}

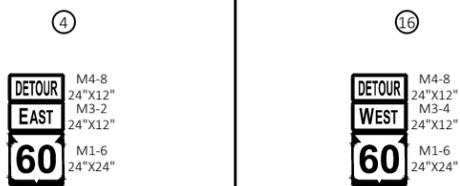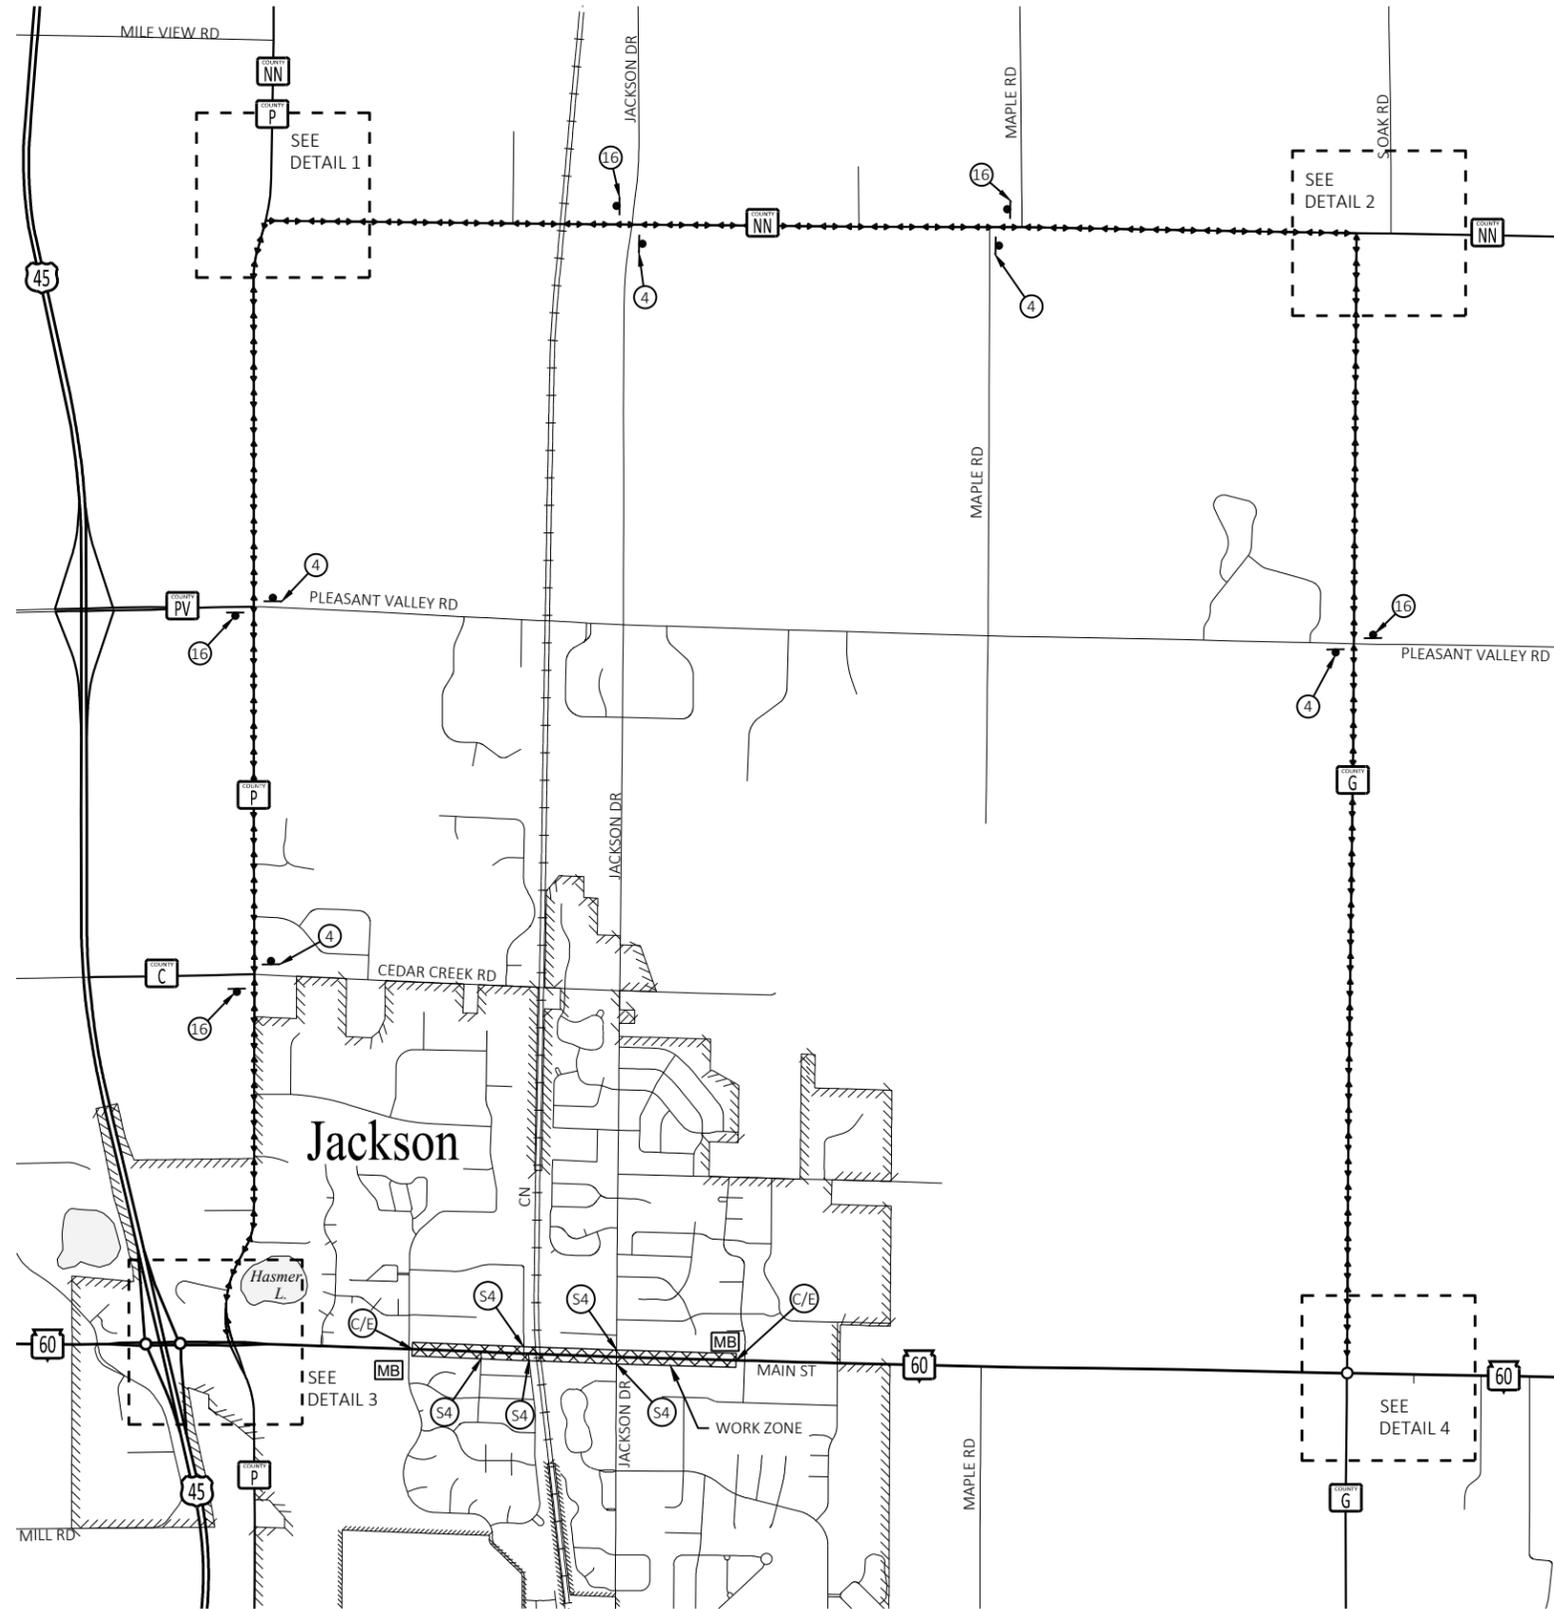


Revisions:	Job No: VOJ 22-01	Designed: JAC
	Date: 10/04/2022	Drawn: AIS
		Checked: TLL

**G GREMMER & ASSOCIATES, INC.**  
 CONSULTING ENGINEERS  
 93 South Pioneer Road, Suite 300  
 Fond du Lac, WI 54935  
 (920) 924-5720  
 Stevens Point • Fond du Lac

Village of Jackson, WI  
 STH 60 - Utility Upgrades  
 CTH P - Ridgeway Drive

DETOUR

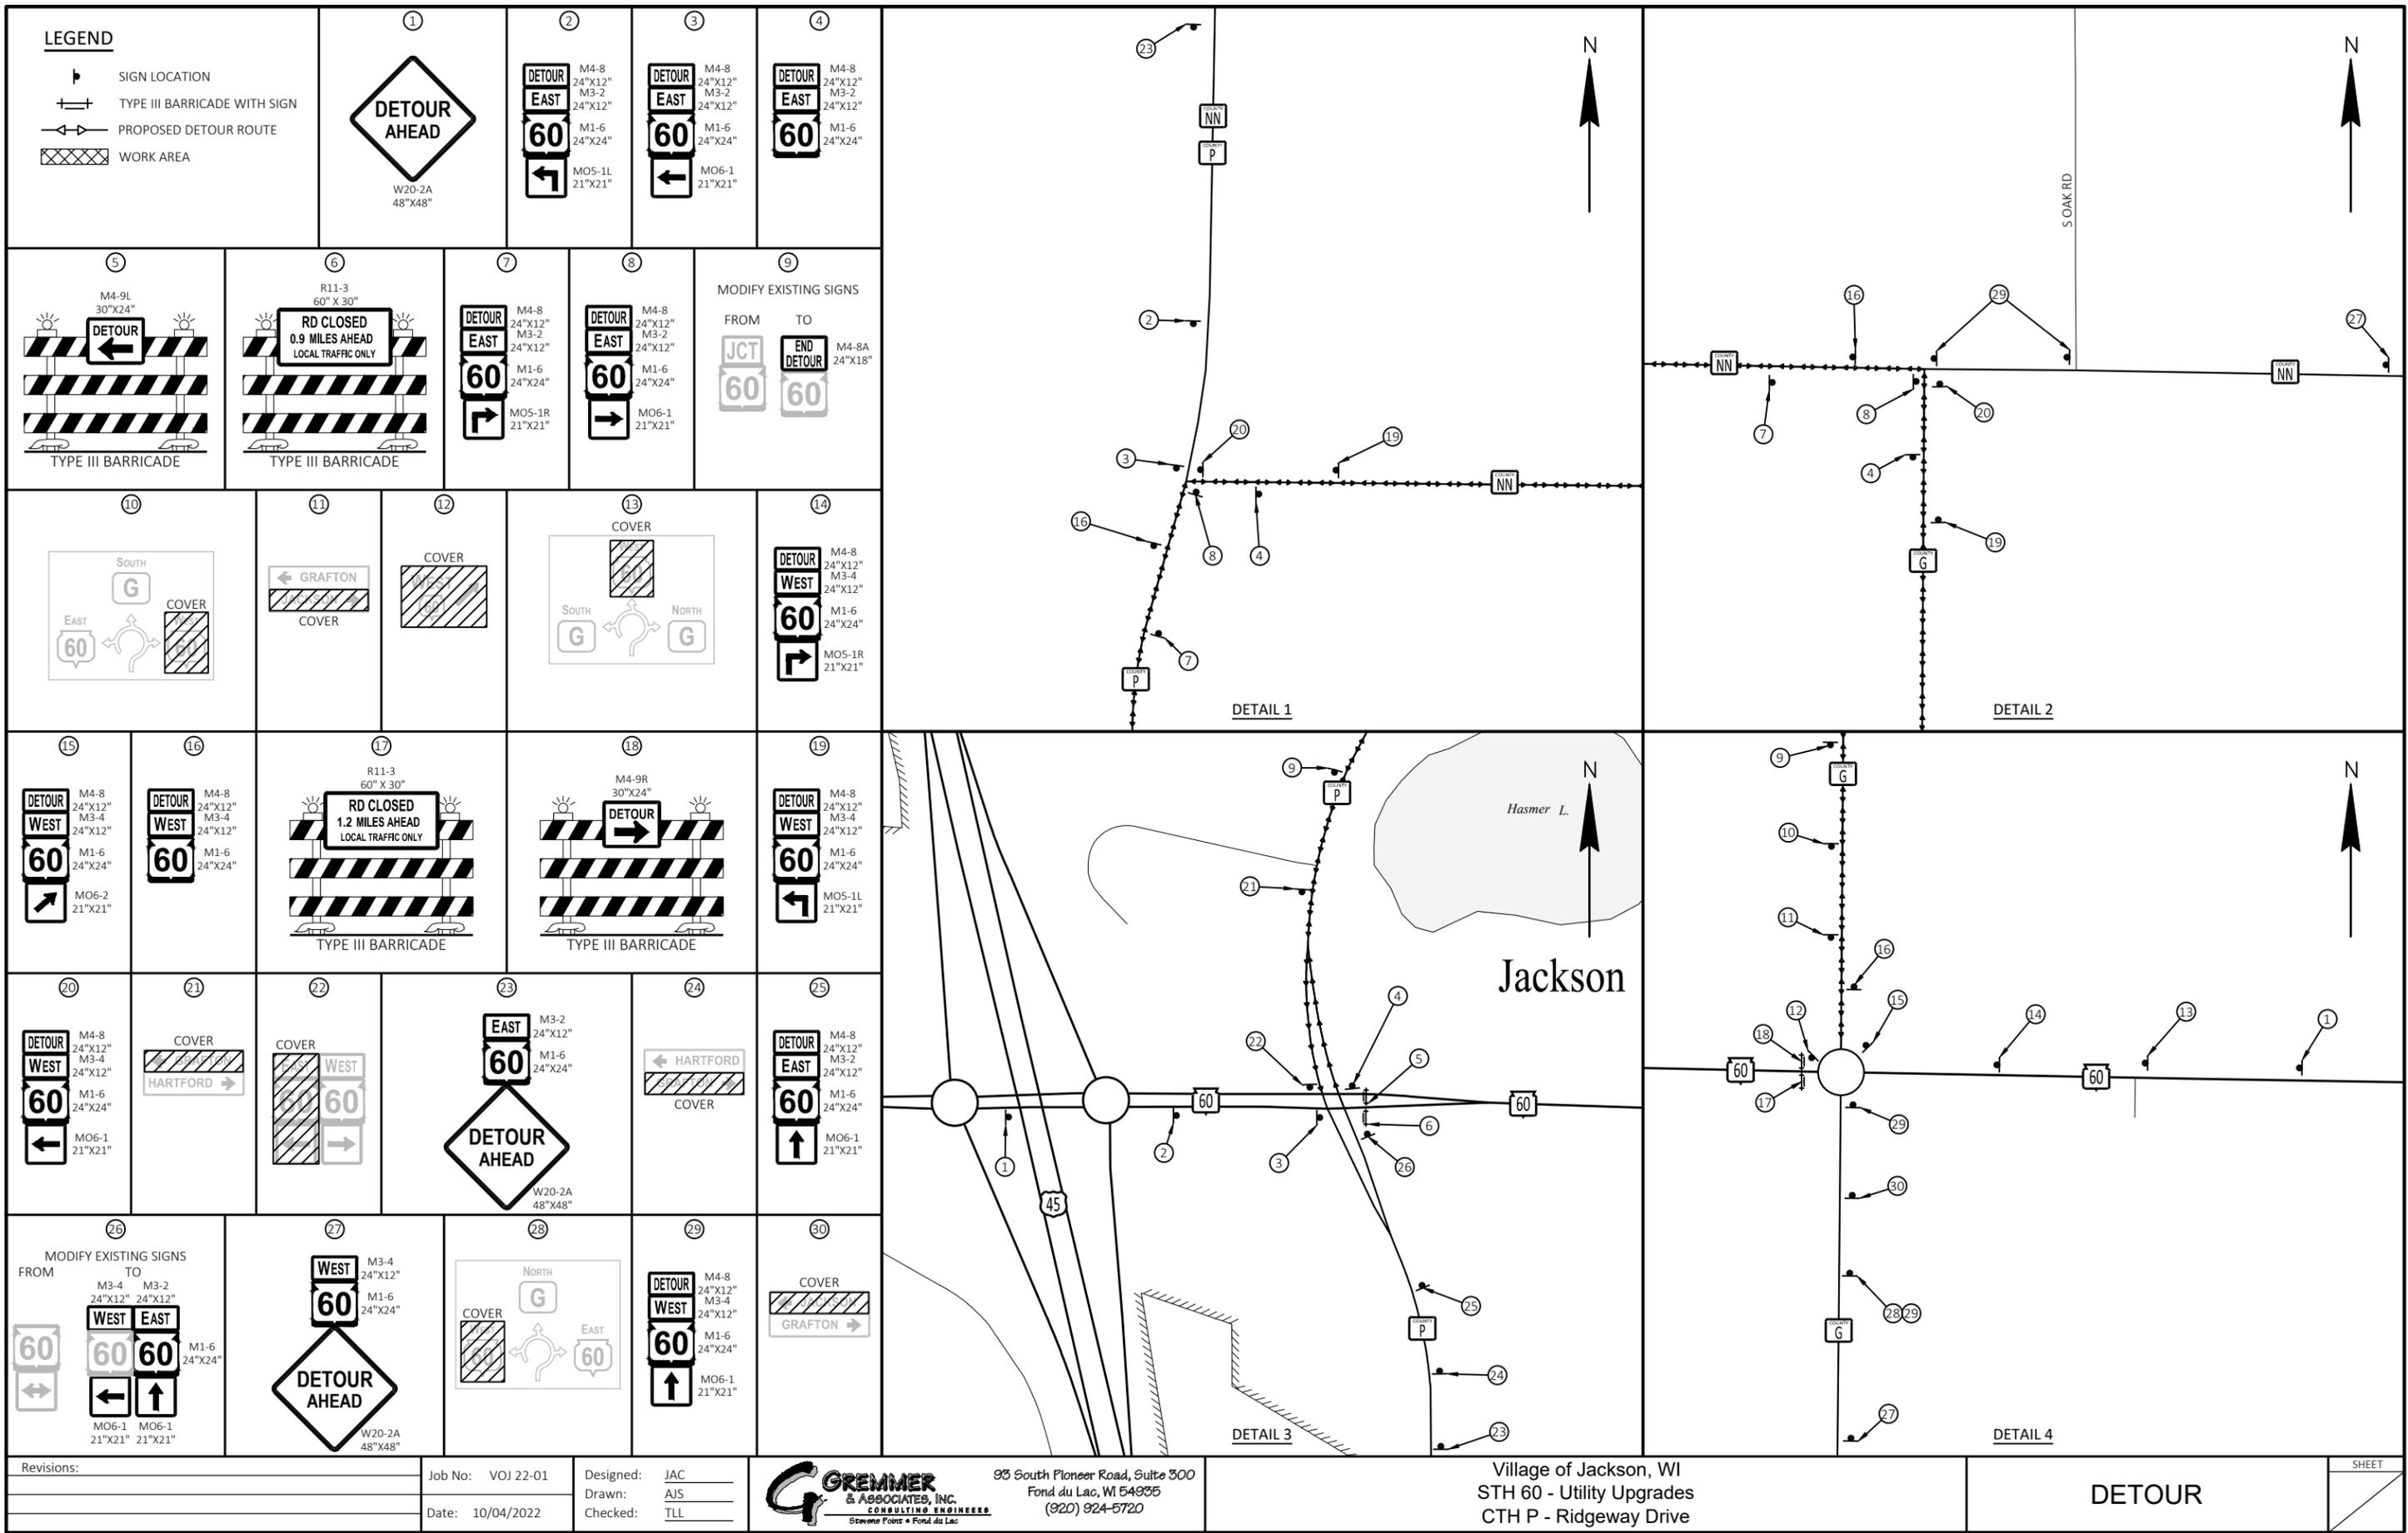

**LEGEND**

- SIGN LOCATION
- TYPE III BARRICADE WITH SIGN
- PROPOSED DETOUR ROUTE
- WORK AREA

① W20-2A 48"X48"

② M4-8 24"X12"  
M3-2 24"X12"  
M1-6 24"X24"  
MO5-1L 21"X21"

③ M4-8 24"X12"  
M3-2 24"X12"  
M1-6 24"X24"  
MO6-1 21"X21"

④ M4-8 24"X12"  
M3-2 24"X12"  
M1-6 24"X24"

⑤ M4-9L 30"X24"

⑥ R11-3 60" X 30"  
RD CLOSED  
0.9 MILES AHEAD  
LOCAL TRAFFIC ONLY

⑦ M4-8 24"X12"  
M3-2 24"X12"  
M1-6 24"X24"  
MO5-1R 21"X21"

⑧ M4-8 24"X12"  
M3-2 24"X12"  
M1-6 24"X24"  
MO6-1 21"X21"

⑨ **MODIFY EXISTING SIGNS**  
FROM TO M4-8A 24"X18"

⑩ SOUTH  
EAST  
COVER

⑪ GRAFTON  
COVER

⑫ COVER

⑬ SOUTH NORTH  
COVER

⑭ M4-8 24"X12"  
M3-4 24"X12"  
M1-6 24"X24"  
MO5-1R 21"X21"

⑮ M4-8 24"X12"  
M3-4 24"X12"  
M1-6 24"X24"  
MO6-2 21"X21"

⑯ M4-8 24"X12"  
M3-4 24"X12"  
M1-6 24"X24"

⑰ R11-3 60" X 30"  
RD CLOSED  
1.2 MILES AHEAD  
LOCAL TRAFFIC ONLY

⑱ M4-9R 30"X24"

⑲ M4-8 24"X12"  
M3-4 24"X12"  
M1-6 24"X24"  
MO5-1L 21"X21"

⑳ M4-8 24"X12"  
M3-4 24"X12"  
M1-6 24"X24"  
MO6-1 21"X21"

㉑ HARTFORD  
COVER

㉒ WEST  
COVER

㉓ M3-2 24"X12"  
M1-6 24"X24"  
W20-2A 48"X48"

㉔ HARTFORD  
COVER

㉕ M4-8 24"X12"  
M3-2 24"X12"  
M1-6 24"X24"  
MO6-1 21"X21"





㉖ **MODIFY EXISTING SIGNS**  
FROM TO M3-4 24"X12"  
M3-2 24"X12"  
M1-6 24"X24"

㉗ M3-4 24"X12"  
M1-6 24"X24"  
W20-2A 48"X48"

㉘ NORTH  
COVER

㉙ M4-8 24"X12"  
M3-4 24"X12"  
M1-6 24"X24"  
MO6-1 21"X21"

㉚ GRAFTON  
COVER

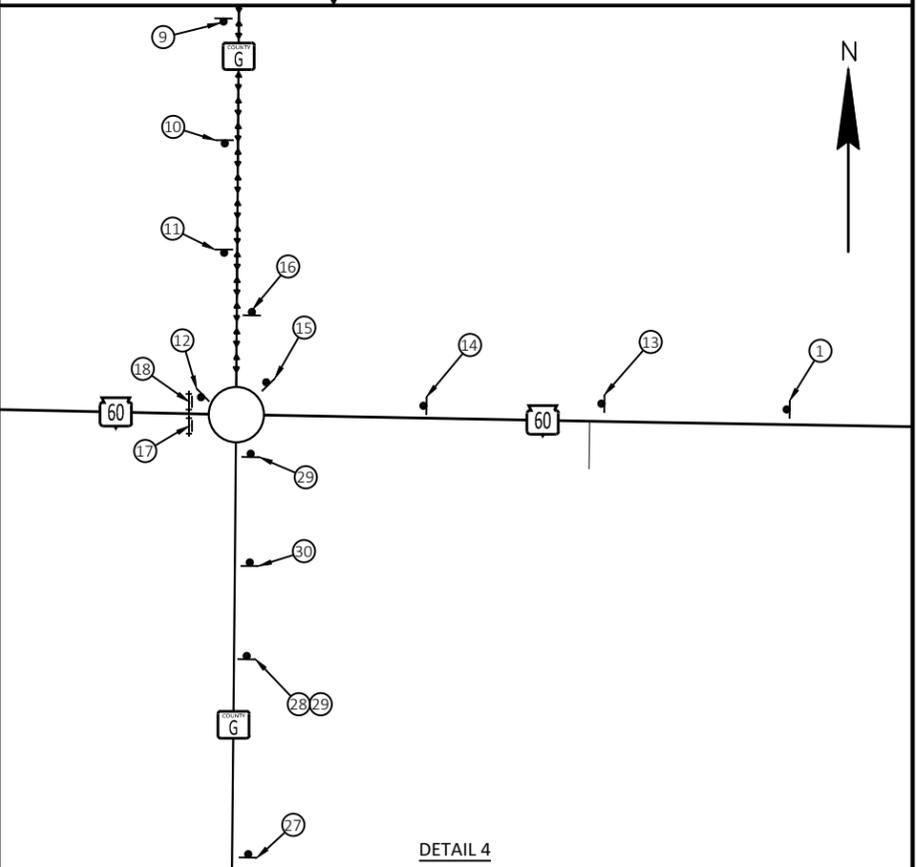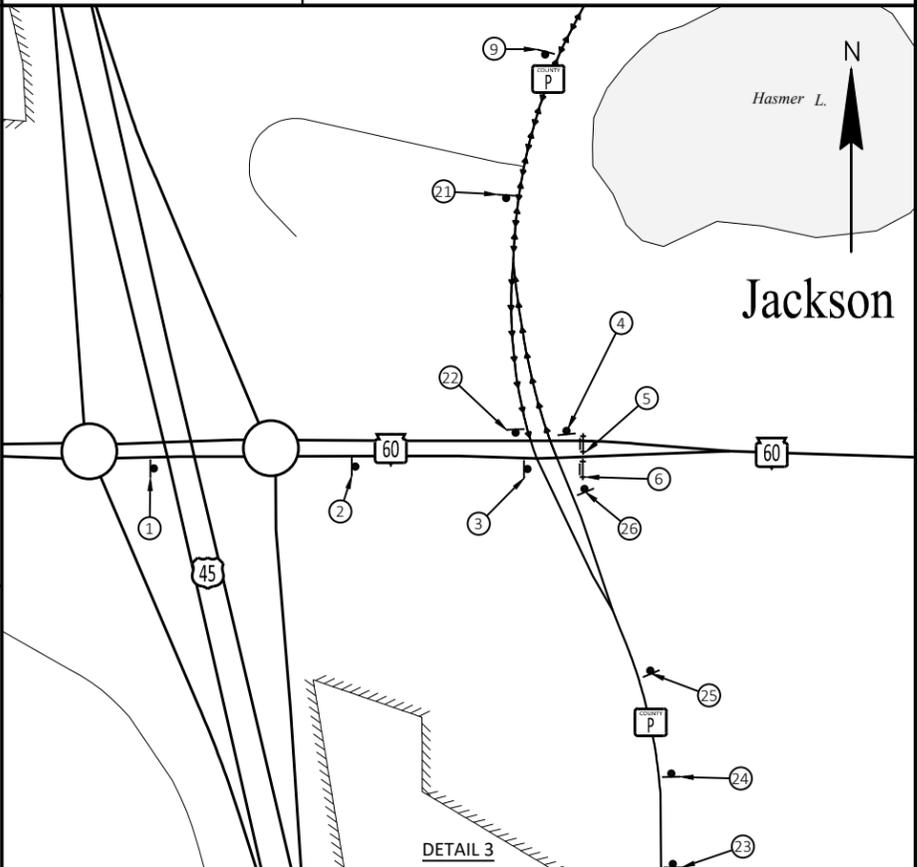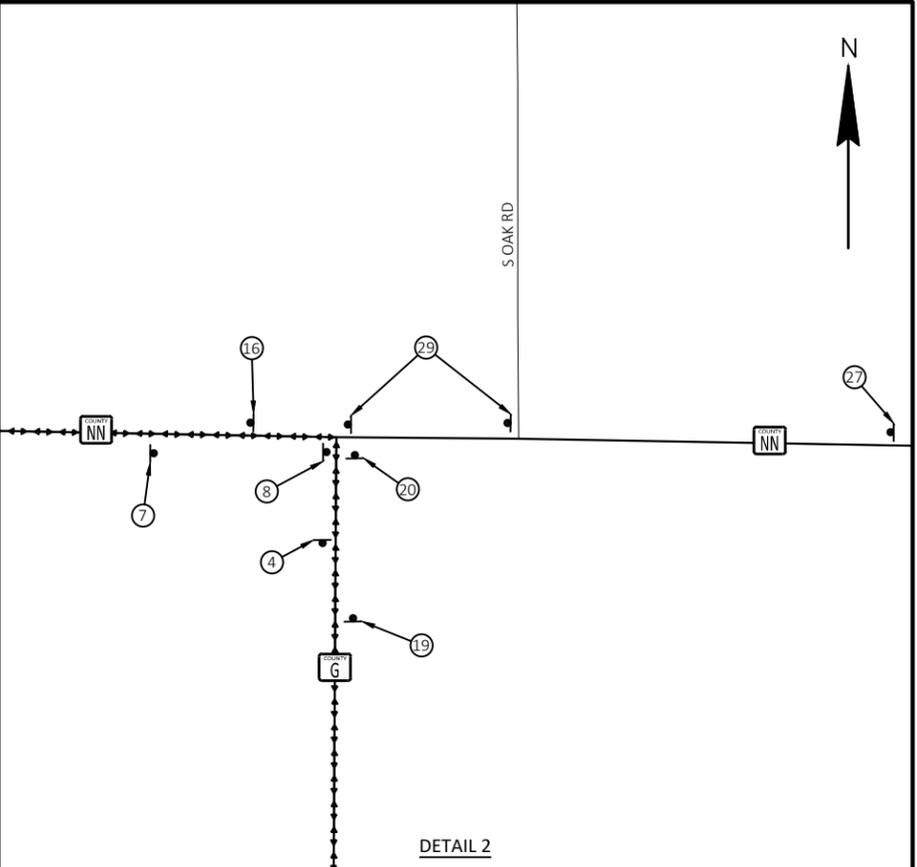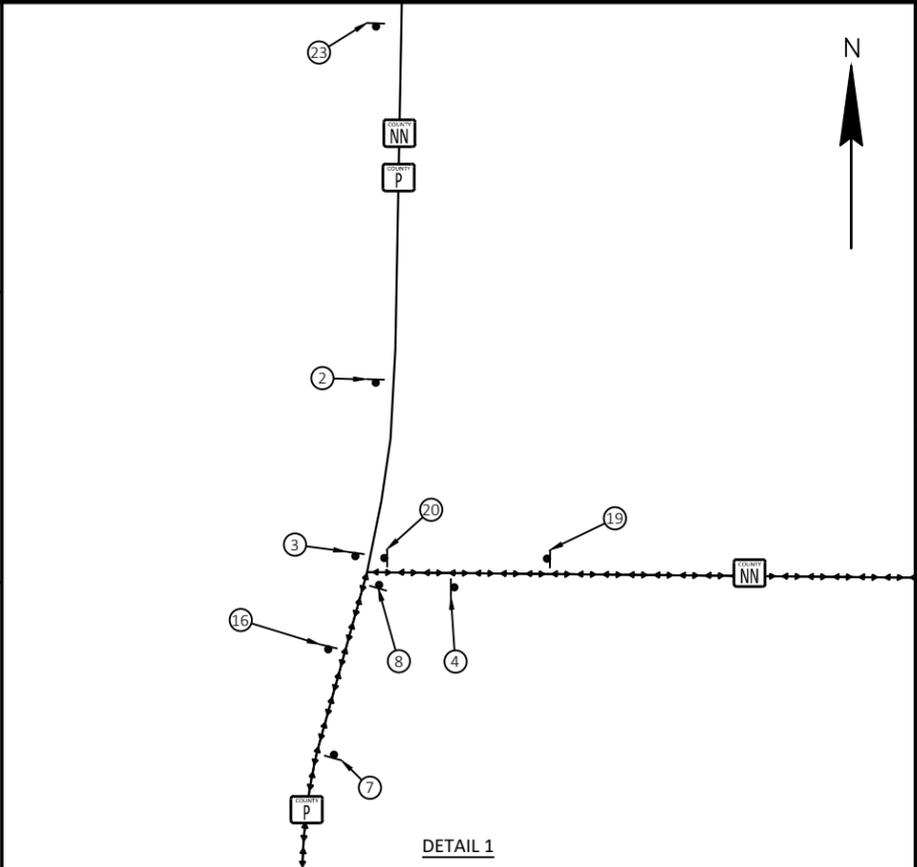

Revisions:	Job No: VOJ 22-01	Designed: JAC	<p>93 South Pioneer Road, Suite 300 Fond du Lac, WI 54935 (920) 924-5720</p>	<p>Village of Jackson, WI STH 60 - Utility Upgrades CTH P - Ridgeway Drive</p>	<p>SHEET</p> <p style="text-align: center;">DETOUR</p>
	Date: 10/04/2022	Drawn: AIS			
		Checked: TLL			